 



Reproduced by permission of Ordnance Survey on behalf of the Controller of Her Majesty's Stationery Office
All rights reserved. © Crown Copyright licence no. 100022432

SITE AREA PLAN



 
SITE PHOTOGRAPH

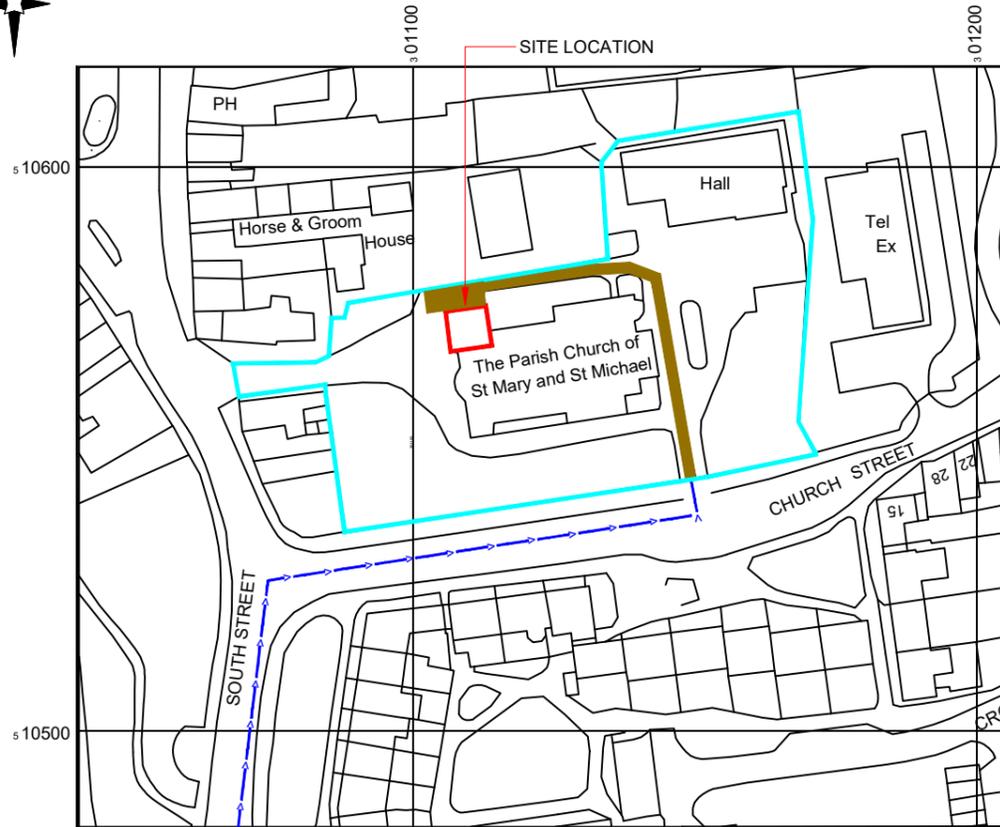

Reproduced by permission of Ordnance Survey on behalf of the Controller of Her Majesty's Stationery Office
All rights reserved. © Crown Copyright licence no. 100022432

NGR E: 301100 N: 510570

SITE LOCATION PLAN



GOOGLE MAPS QR CODE

GOOGLE MAPS - <https://goo.gl/maps/TzqxwB5QGRJcB2bYR9>

GOOGLE MAPS - <https://goo.gl/maps/GYPCULzWiaUqZ5G27>

NOTES:
1. ALL DIMENSIONS IN MM UNLESS OTHERWISE NOTED.
DIRECTIONS TO SITE:
LEAVE THE M6 AT J36 AND EXIT TOWARDS A590. FOLLOW A590 TO BARROW/MINTHORPE/A6. TURN RIGHT ONTO C5009. TURN LEFT ONTO C5051/STATION ROAD. TURN RIGHT ONTO C5051/PRINCE'S STREET. TURN LEFT ONTO C5051/CHURCH STREET. TURN RIGHT ONTO HIGH CROSS BROW. TURN RIGHT ONTO CORNEY FELL. FOLLOW A595 TO VALE VIEW IN EGERMONT. AT ROUNDABOUT TAKE 1ST EXIST ON VALE VIEW. SLIGHT RIGHT ONTO SOUTH STREET. TURN RIGHT ONTO CHURCH STREET. SITE IS ON THE RIGHT

Lease Demise: 
Site Provider's Property Boundary: 
Access Route To Site: 
Access Route: 

Master: M002	MBNL / EE / H3G:	Project: MBNL - 3UK BUY-IN	Purpose of Issue: Detailed Design	Issue: B
Date: 24/03/2023	Revision / Upgrade Description:	Major Rev - Power Notes Revised, Cabinet Details Added, NGR Corrected, GPS Mounting Position Changed, Schedules Updated & Antenna Mounting Scheme Revised as Per Site Revisit/Notes		
Drawn: S.Bevan	Checked: A.Dobson	Approved: A.Dobson		
Master: M001	MBNL / EE / H3G:	Project: MBNL - 3UK BUY-IN	Purpose of Issue: Detailed Design	Issue: A
Date: 29/11/2022	Revision / Upgrade Description:	First Issue - Detailed Design		
Drawn: R.Sweeney	Checked: A.Dobson	Approved: A.Dobson		



Hutchison 3G UK Limited
Green Park, 450 Longwater Avenue
Reading, RG20 3UR
Tel: 01628 765 900
Fax: 01628 765 901



Hatfield Business Park
Hatfield
Hertfordshire
AL10 9BW
Tel: 01707 315000
Fax: 01707 319001

MBNL Mobile Broadband Network Limited
Sixth Floor, Thames Tower, Station Road, Reading, RG1 1LX

Design Consultant & Principal Contractor:



Unit E, Madison Place, Northampton Road,
Manchester, M40 5AG
Tel: 0161 785 4500 Fax: 0161 785 4501
Web: www.clarke-telecom.com

Site Name: PARISH CHURCH EGREMONT

Site ID: 1208338

Address: PARISH CHURCH EGREMONT
ST MARY AND ST MICHAEL
SOUTH STREET
EGREMONT, CUMBRIA
CA22 2AW

Title: 002 SITE LOCATION PLAN


Project: MBNL - 3UK BUY-IN

Purpose of Issue: DETAILED DESIGN

EE Cell ID: 12086	MBNL Cell ID: COP020	3UK Cell ID: CA0190
-----------------------------	--------------------------------	-------------------------------

Master Drawing No: 1208338_COP020_12086_CA0190_M002 Issue: B

100mm
50mm
10mm

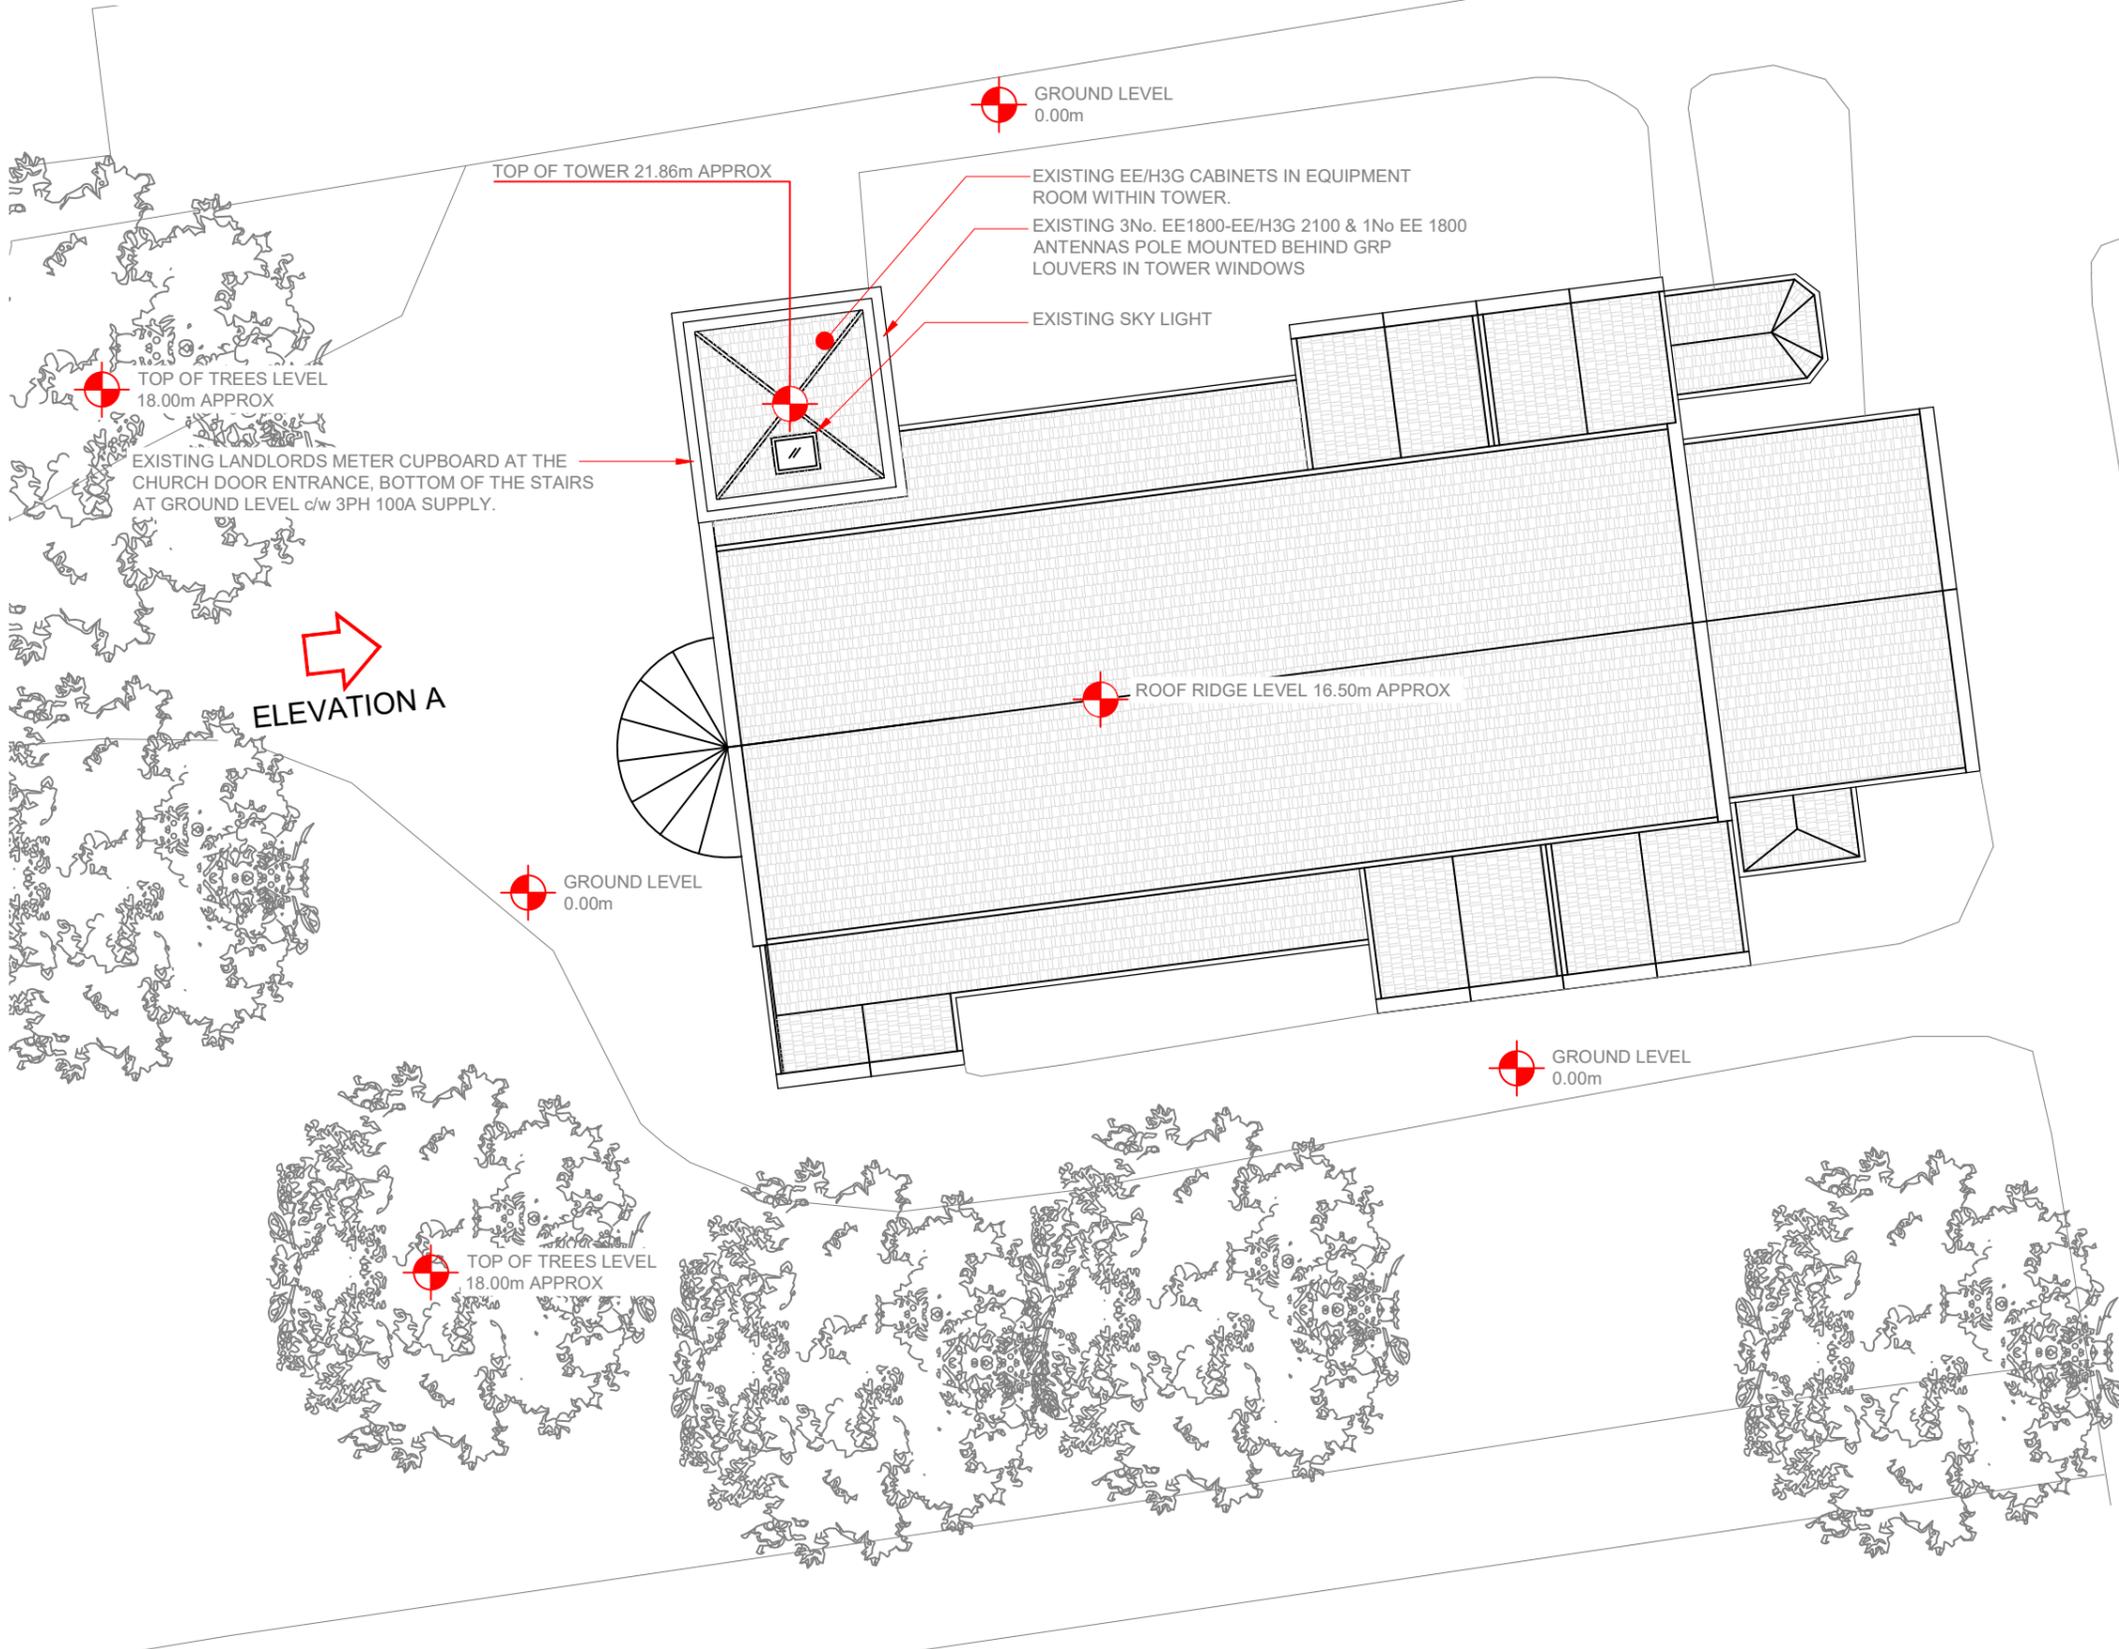

EXISTING SITE PLAN



100mm
50mm
10mm

NOTES:

- ALL DIMENSIONS IN MM UNLESS OTHERWISE NOTED.

Master:	MBNL / EE / H3G:	Project:	Purpose of Issue:	Issue:
M002	MBNL	MBNL - 3UK BUY-IN	Detailed Design	B
Date:	24/03/2023	Revision / Upgrade Description:		
Drawn:	S.Bevan	Major Rev - Power Notes Revised, Cabinet Details Added, NGR Corrected, GPS Mounting Position Changed, Schedules Updated & Antenna Mounting Scheme Revised as Per Site Revisit/Notes		
Checked:	A.Dobson			
Approved:	A.Dobson			
Master:	MBNL / EE / H3G:	Project:	Purpose of Issue:	Issue:
M001	MBNL	MBNL - 3UK BUY-IN	Detailed Design	A
Date:	29/11/2022	Revision / Upgrade Description:		
Drawn:	R.Sweeney	First Issue - Detailed Design		
Checked:	A.Dobson			
Approved:	A.Dobson			

 <p>Hutchison 3G UK Limited Green Park, 450 Longwater Avenue Reading, RG20 3UR Tel: 01628 765 900 Fax: 01628 765 901</p>	 <p>Hatfield Business Park Hatfield Hertfordshire AL10 9BW Tel: 01707 315000 Fax: 01707 319001</p>
---	---

MBNL Mobile Broadband Network Limited
Sixth Floor, Thames Tower, Station Road, Reading, RG1 1LX

Design Consultant & Principal Contractor:

CLARKE
telecom

Unit E, Madison Place, Northampton Road,
Manchester, M40 5AG
Tel: 0161 785 4500 Fax: 0161 785 4501
Web: www.clarke-telecom.com

Site Name: **PARISH CHURCH EGREMONT**

Site ID: **1208338**

Address: **PARISH CHURCH EGREMONT
ST MARY AND ST MICHAEL
SOUTH STREET
EGREMONT, CUMBRIA
CA22 2AW**


Title: **100 EXISTING SITE PLAN**

Project: **MBNL - 3UK BUY-IN**

Purpose of Issue: **DETAILED DESIGN**

EE Cell ID: 12086	MBNL Cell ID: COP020	3UK Cell ID: CA0190
-----------------------------	--------------------------------	-------------------------------

Master Drawing No: **1208338_COP020_12086_CA0190_M002** Issue: **B**

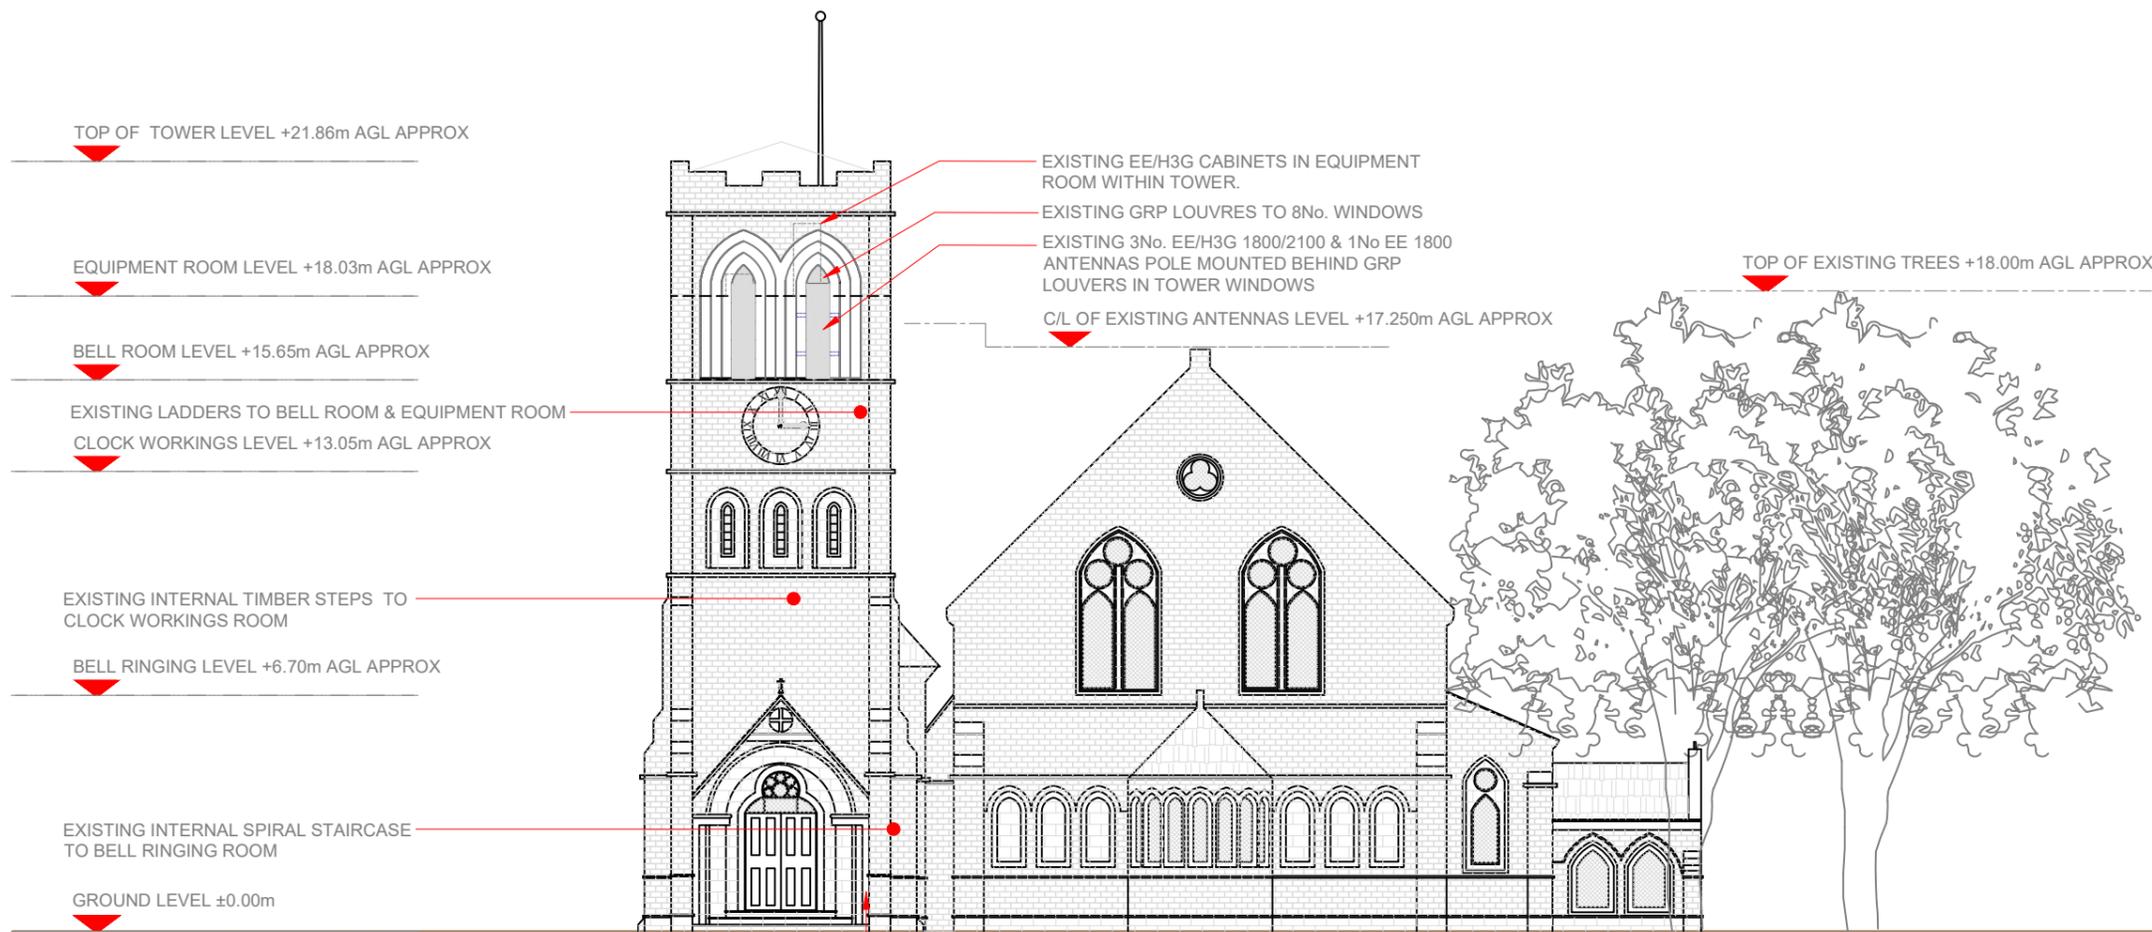

EXISTING SITE ELEVATION A



NOTES:

- ALL DIMENSIONS IN MM UNLESS OTHERWISE NOTED.

Master: M002	MBNL / EE / H3G: MBNL	Project: MBNL - 3UK BUY-IN	Purpose of Issue: Detailed Design	Issue: B
Date: 24/03/2023	Drawn: S.Bevan	Revision / Upgrade Description: Major Rev - Power Notes Revised, Cabinet Details Added, NGR Corrected, GPS Mounting Position Changed, Schedules Updated & Antenna Mounting Scheme Revised as Per Site Revisit/Notes		
Checked: A.Dobson	Approved: A.Dobson			
Master: M001	MBNL / EE / H3G: MBNL	Project: MBNL - 3UK BUY-IN	Purpose of Issue: Detailed Design	Issue: A
Date: 29/11/2022	Drawn: R.Sweeney	Revision / Upgrade Description: First Issue - Detailed Design		
Checked: A.Dobson	Approved: A.Dobson			



Hutchison 3G UK Limited
Green Park, 450 Longwater Avenue
Reading, RG20 3UR
Tel: 01628 765 900
Fax: 01628 765 901

H3G Base Station Information line:
0845 6043000
Available 9am-5pm Monday to Friday



Hatfield Business Park
Hatfield
Hertfordshire
AL10 9BW
Tel: 01707 315000
Fax: 01707 319001

MBNL Mobile Broadband Network Limited
Sixth Floor, Thames Tower, Station Road, Reading, RG1 1LX

Design Consultant & Principal Contractor:



Unit E, Madison Place, Northampton Road,
Manchester, M40 5AG
Tel: 0161 785 4500 Fax: 0161 785 4501
Web: www.clarke-telecom.com

Site Name: **PARISH CHURCH EGREMONT**

Site ID: **1208338**

Address: **PARISH CHURCH EGREMONT
ST MARY AND ST MICHAEL
SOUTH STREET
EGREMONT, CUMBRIA
CA22 2AW**

Title: **150 EXISTING SITE ELEVATION**

Project: **MBNL - 3UK BUY-IN**

Purpose of Issue: **DETAILED DESIGN**

EE Cell ID: 12086	MBNL Cell ID: COP020	3UK Cell ID: CA0190
-----------------------------	--------------------------------	-------------------------------

Master Drawing No: **1208338_COP020_12086_CA0190_M002** Issue: **B**



GROUND LEVEL
0.00m

TOP OF TOWER 21.86m APPROX

PROPOSED H3G 1No GPS ON MAFI 3272 BRACKET FIXED TO ANTENNA SUPPORT POLE (BELOW ANTENNA)

EXISTING EE/H3G CABINETS IN EQUIPMENT ROOM WITHIN TOWER. PROPOSED H3G EQUIPMENT TO BE INSTALLED WITHIN. SEE DRG 330

EXISTING LANDLORDS METER CUPBOARD AT THE CHURCH DOOR ENTRANCE, BOTTOM OF THE STAIRS AT GROUND LEVEL c/w 3PH 100A SUPPLY (DUE TO NO FUSE PULL TEST, ASSUME DNO SUPPLY IS 63A)

EXISTING PEDESTRIAN ACCESS ONTO SOUTH STREET

ELEVATION A

TOP OF TREES LEVEL
18.00m APPROX

GROUND LEVEL
0.00m

ROOF RIDGE LEVEL 16.50m APPROX

GROUND LEVEL
0.00m

EXISTING VEHICLE & PEDESTRIAN ACCESS ONTO CHURCH STREET

TOP OF TREES LEVEL
18.00m APPROX

PROPOSED H3G SITE PLAN



NOTES:

- ALL DIMENSIONS IN MM UNLESS OTHERWISE NOTED.

NOTE:
ALL EXISTING FEEDERS TO BE TESTED & RE-USED. EXISTING CABLE MANAGEMENT TO BE UTILISED WHERE POSSIBLE.

NOTE:
PROPOSED GPS NODE CANNOT BE FIXED TO BUILDING EXTERIOR. GPS TO BE MOUNTED OFF ANTENNA POLE BELOW ANTENNA ON SECTOR D.

Master	MBNL / EE / H3G	Project	Purpose of Issue	Issue
M002	MBNL	MBNL - 3UK BUY-IN	Detailed Design	B
Date:	24/03/2023	Revision / Upgrade Description:		
Drawn:	S.Bevan	Major Rev - Power Notes Revised, Cabinet Details Added, NGR Corrected, GPS Mounting Position Changed, Schedules Updated & Antenna Mounting Scheme Revised as Per Site Revisit/Notes		
Checked:	A.Dobson			
Approved:	A.Dobson			
Master	MBNL / EE / H3G	Project	Purpose of Issue	Issue
M001	MBNL	MBNL - 3UK BUY-IN	Detailed Design	A
Date:	29/11/2022	Revision / Upgrade Description:		
Drawn:	R.Sweeney	First Issue - Detailed Design		
Checked:	A.Dobson			
Approved:	A.Dobson			



Hutchison 3G UK Limited
Green Park, 450 Longwater Avenue
Reading, RG20 3JR
Tel: 01628 765 900
Fax: 01628 765 901



Hatfield Business Park
Hatfield
Hertfordshire
AL10 9BW
Tel: 01707 315000
Fax: 01707 319001

H3G Base Station Information Line:
0845 6043000
Available 8am-8pm Monday to Friday



Mobile Broadband Network Limited
Sixth Floor, Thames Tower, Station Road, Reading, RG1 1LX

Design Consultant & Principal Contractor:



Unit E, Madison Place, Northampton Road,
Manchester, M40 5AG
Tel: 0161 785 4500 Fax: 0161 785 4501
Web: www.clarke-telecom.com

Site Name: PARISH CHURCH EGREMONT

Site ID: 1208338

Address: PARISH CHURCH EGREMONT
ST MARY AND ST MICHAEL
SOUTH STREET
EGREMONT, CUMBRIA
CA22 2AW

Title: 210 PROPOSED H3G SITE PLAN


Project: MBNL - 3UK BUY-IN

Purpose of Issue: DETAILED DESIGN


EE Cell ID:	MBNL Cell ID:	3UK Cell ID:
12086	COP020	CA0190

Master Drawing No: 1208338_COP020_12086_CA0190_M002 Issue: B

100mm
50mm
10mm

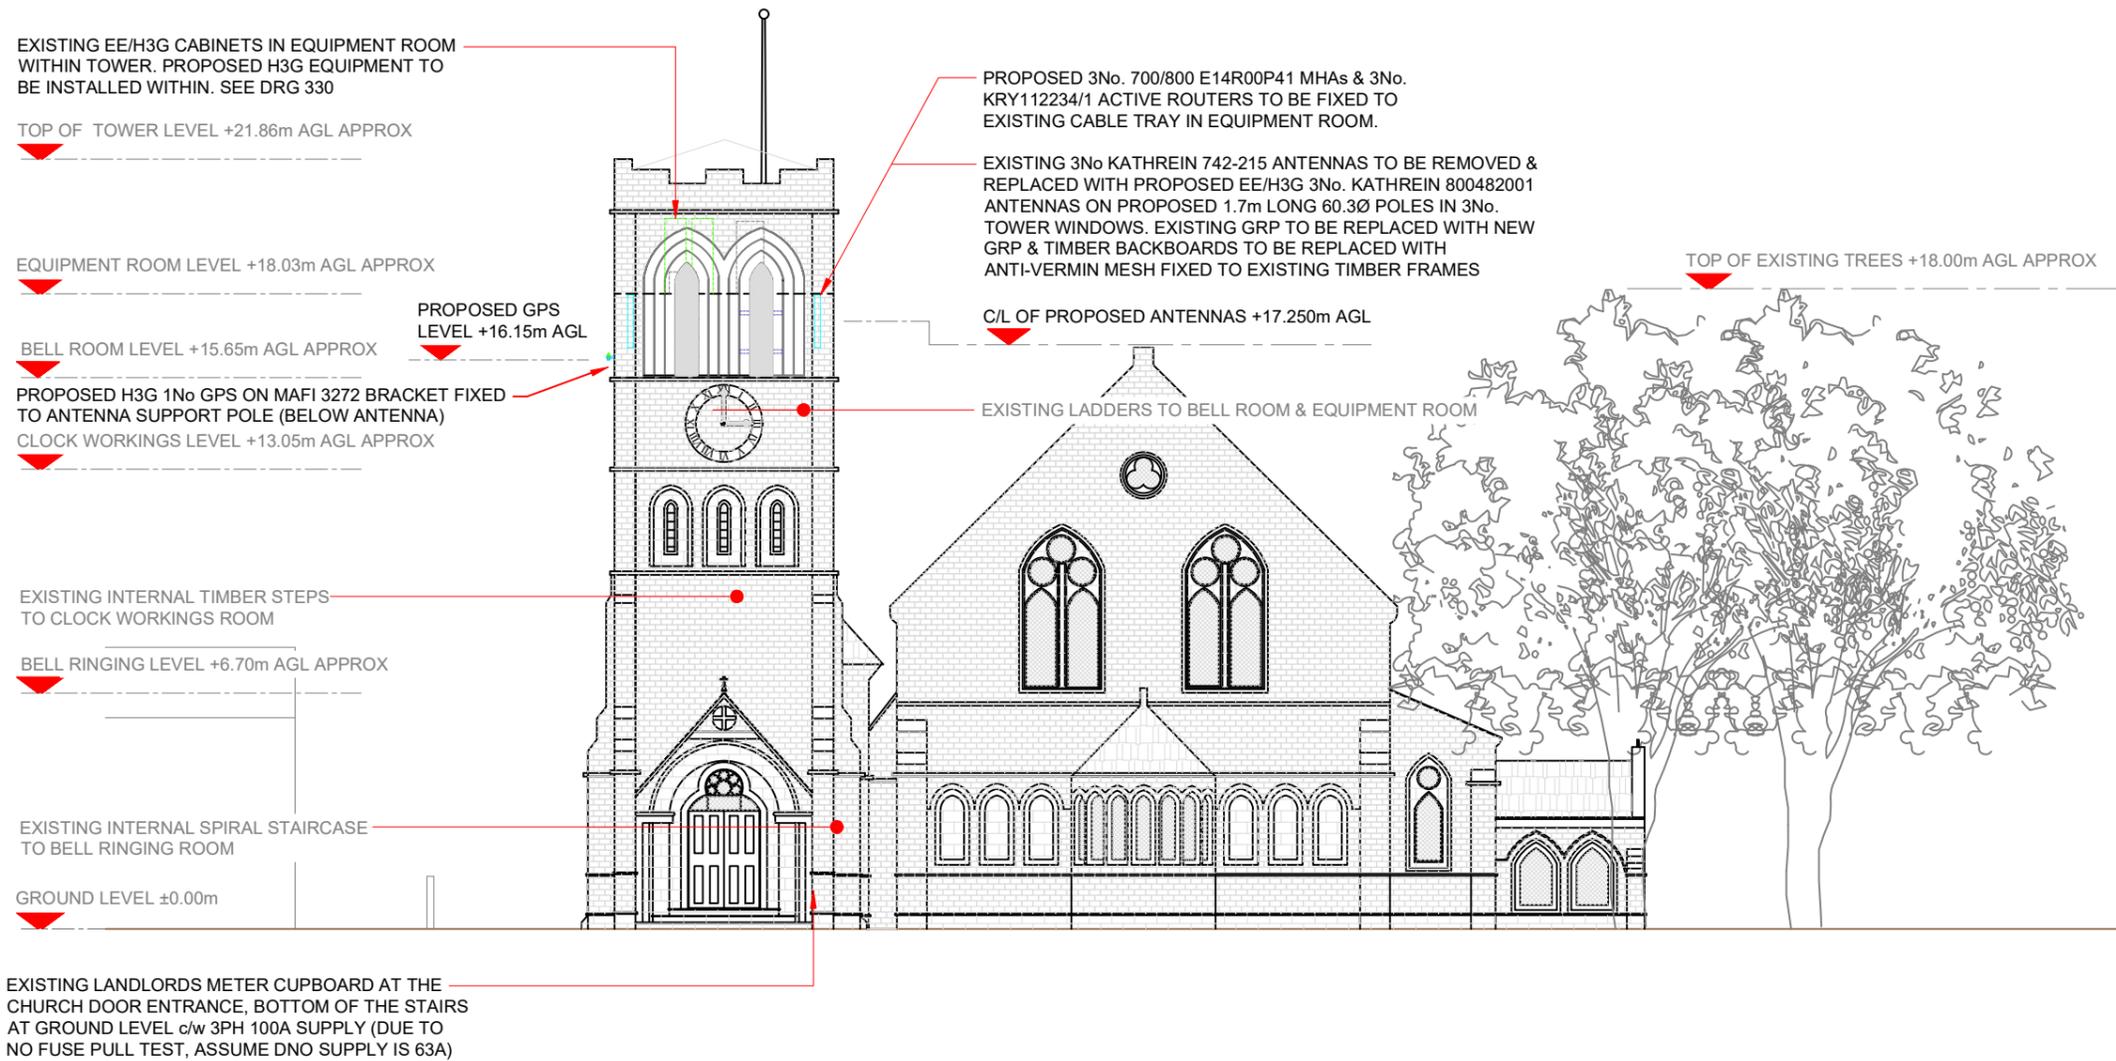

PROPOSED H3G ELEVATION A

 

NOTES:

1. ALL DIMENSIONS IN MM UNLESS OTHERWISE NOTED.

NOTE:
ALL EXISTING FEEDERS TO BE TESTED & RE-USED. EXISTING CABLE MANAGEMENT TO BE UTILISED WHERE POSSIBLE.

NOTE:
PROPOSED GPS NODE CANNOT BE FIXED TO BUILDING EXTERIOR. GPS TO BE MOUNTED OFF ANTENNA POLE BELOW ANTENNA ON SECTOR D.

Master: M002	MBNL / EE / H3G: MBNL	Project: MBNL - 3UK BUY-IN	Purpose of Issue: Detailed Design	Issue: B
Date: 24/03/2023	Drawn: S.Bevan	Revision / Upgrade Description: Major Rev - Power Notes Revised, Cabinet Details Added, NGR Corrected, GPS Mounting Position Changed, Schedules Updated & Antenna Mounting Scheme Revised as Per Site Revisit/Notes		
Checked: A.Dobson	Approved: A.Dobson			
Master: M001	MBNL / EE / H3G: MBNL	Project: MBNL - 3UK BUY-IN	Purpose of Issue: Detailed Design	Issue: A
Date: 29/11/2022	Drawn: R.Sweeney	Revision / Upgrade Description: First Issue - Detailed Design		
Checked: A.Dobson	Approved: A.Dobson			

Hutchison 3G UK Limited
Green Park, 450 Longwater Avenue
Reading, RG20 3UR
Tel: 01628 765 900
Fax: 01628 765 901

H3G Base Station Information line:
0845 6043000
Available 8am-8pm Monday to Friday

Hatfield Business Park
Hatfield
Hertfordshire
AL10 9BW
Tel: 01707 315000
Fax: 01707 319001

MBNL Mobile Broadband Network Limited
Sixth Floor, Thames Tower, Station Road, Reading, RG1 1LX

Design Consultant & Principal Contractor:

Unit E, Madison Place, Northampton Road,
Manchester, M40 5AG
Tel: 0161 785 4500 Fax: 0161 785 4501
Web: www.clarke-telecom.com

Site Name: **PARISH CHURCH EGREMONT**

Site ID: **1208338**

Address: **PARISH CHURCH EGREMONT
ST MARY AND ST MICHAEL
SOUTH STREET
EGREMONT, CUMBRIA
CA22 2AW**


Title: **260 PROPOSED H3G ELEVATION**

Project: **MBNL - 3UK BUY-IN**

Purpose of Issue: **DETAILED DESIGN**

EE Cell ID: 12086	MBNL Cell ID: COP020	3UK Cell ID: CA0190
-----------------------------	--------------------------------	-------------------------------


Master Drawing No: **1208338_COP020_12086_CA0190_M002** Issue: **B**

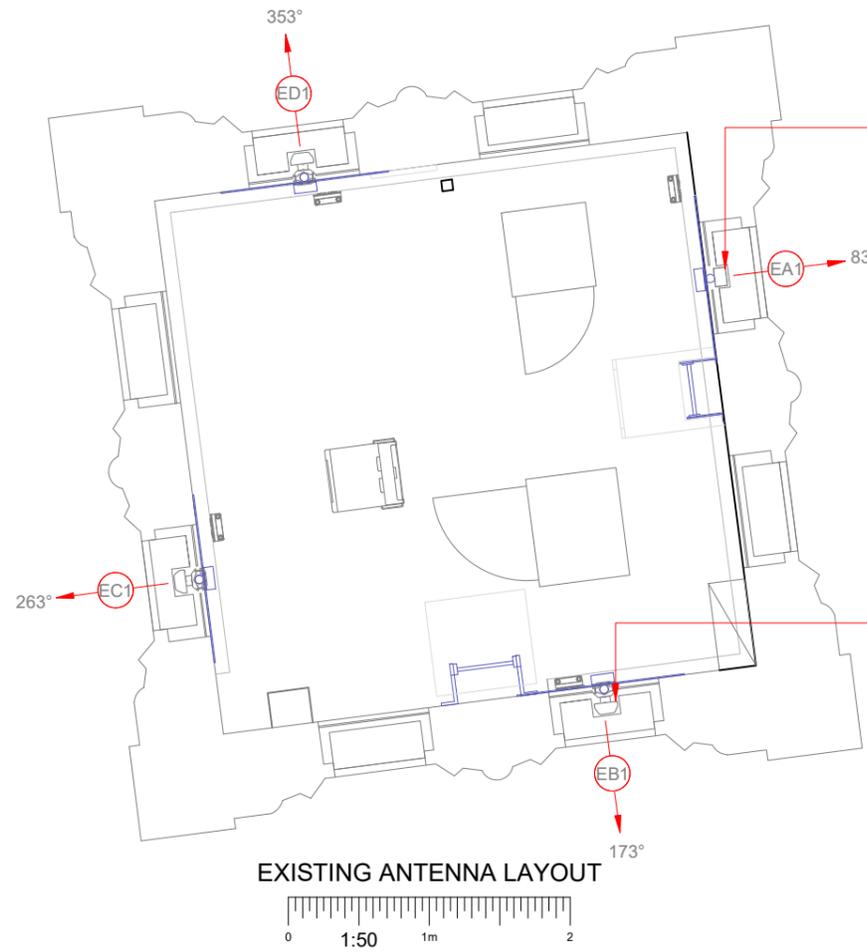

EXISTING EE 1No. CSA CS0401A ANTENNA ON EXISTING POLE MOUNTED BEHIND EXISTING GRP LOUVRE IN TOWER WINDOW. WITH 1No COMMSCOPE E15S09P75 1800 MHA FIXED TO EXISTING CABLE TRAY.

EXISTING EE/H3G 3No. KATHREIN 742-215 ANTENNAS ON EXISTING POLES MOUNTED BEHIND EXISTING GRP LOUVRES IN TOWER WINDOWS WITH 3No KEALUS TMA2053F03V4-4C 1800/2100 MHA'S FIXED TO EXISTING CABLE TRAY.

 EXISTING ANTENNA LAYOUT



NOTES:

- ALL DIMENSIONS IN MM UNLESS OTHERWISE NOTED.


Master: M002	MBNL / EE / H3G: MBNL	Project: MBNL - 3UK BUY-IN	Purpose of Issue: Detailed Design	Issue: B
Date: 24/03/2023	Drawn: S.Bevan	Revision / Upgrade Description: Major Rev - Power Notes Revised, Cabinet Details Added, NGR Corrected, GPS Mounting Position Changed, Schedules Updated & Antenna Mounting Scheme Revised as Per Site Revisit/Notes		
Checked: A.Dobson	Approved: A.Dobson			
Master: M001	MBNL / EE / H3G: MBNL	Project: MBNL - 3UK BUY-IN	Purpose of Issue: Detailed Design	Issue: A
Date: 29/11/2022	Drawn: R.Sweeney	Revision / Upgrade Description: First Issue - Detailed Design		
Checked: A.Dobson	Approved: A.Dobson			



PROPOSED H3G 1No GPS ON MAFI 3272 BRACKET FIXED TO ANTENNA SUPPORT POLE (BELOW ANTENNA)

NOTE:
EXISTING GRP ANTENNA LOUVRES TO BE REMOVED & REPLACED WITH NEW STRENGTHENED AND NOTCHED/PROFIED LOUVRES TO SUIT PROPOSED ANTENNAS. GRP TO BE DESIGNED BY OTHERS

NOTE:
PROPOSED GPS NODE CANNOT BE FIXED TO BUILDING EXTERIOR. GPS TO BE MOUNTED OFF ANTENNA POLE BELOW ANTENNA ON SECTOR D.

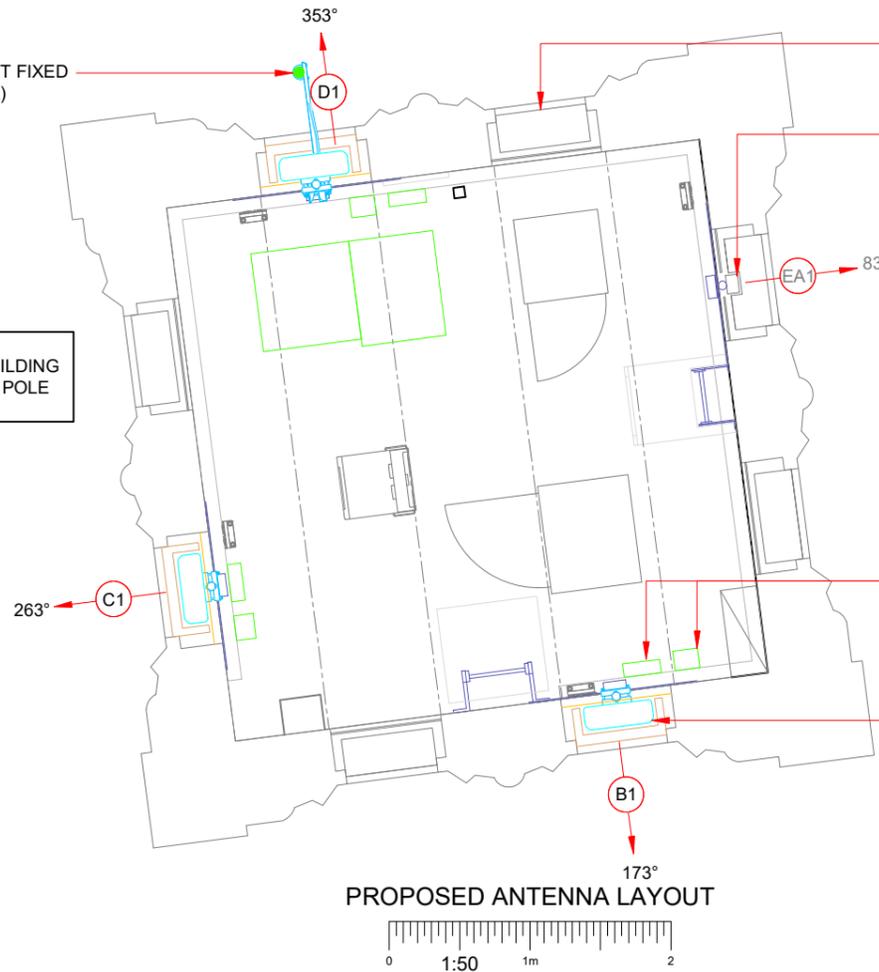


EXISTING ORIGINAL TIMBER LOUVRES WITHIN 4No. VACANT WINDOWS TO REMAIN

EXISTING EE 1No. CSA CS0401A ANTENNA ON EXISTING POLE MOUNTED BEHIND EXISTING GRP LOUVRE IN TOWER WINDOW. WITH 1No COMMSCOPE E15S09P75 1800 MHA FIXED TO EXISTING CABLE TRAY TO REMAIN

PROPOSED 3No. 700/800 E14R00P41 MHAs & 3No. KRY112234/1 ACTIVE ROUTERS TO BE FIXED TO EXISTING CABLE TRAY IN EQUIPMENT ROOM.

EXISTING 3No KATHREIN 742-215 ANTENNAS TO BE REMOVED & REPLACED WITH PROPOSED EE/H3G 3No. KATHREIN 800482001 ANTENNAS ON PROPOSED 1.7m LONG 60.3Ø POLES IN 3No. TOWER WINDOWS. EXISTING GRP TO BE REPLACED WITH NEW GRP & TIMBER BACKBOARDS TO BE REPLACED WITH ANTI-VERMIN MESH FIXED TO EXISTING TIMBER FRAMES

 PROPOSED ANTENNA LAYOUT



Hutchison 3G UK Limited
Green Park, 450 Longwater Avenue
Reading, RG20 3UR
Tel: 01628 765 900
Fax: 01628 765 901

H3G Base Station Information line:
0845 6043000
Available 8am-8pm Monday to Friday

Hatfield Business Park
Hatfield
Hertfordshire
AL10 9BW
Tel: 01707 315000
Fax: 01707 319001

MBNL Mobile Broadband Network Limited
Sixth Floor, Thames Tower, Station Road, Reading, RG1 1LX

Design Consultant & Principal Contractor:

Unit E, Madison Place, Northampton Road,
Manchester, M40 5AG
Tel: 0161 785 4500 Fax: 0161 785 4501
Web: www.clarke-telecom.com

Site Name: PARISH CHURCH EGREMONT

Site ID: 1208338

Address: PARISH CHURCH EGREMONT
ST MARY AND ST MICHAEL
SOUTH STREET
EGREMONT, CUMBRIA
CA22 2AW

Title: 310 ANTENNA LAYOUT


Project: MBNL - 3UK BUY-IN

Purpose of Issue: DETAILED DESIGN



EE Cell ID: 12086	MBNL Cell ID: COP020	3UK Cell ID: CA0190
-----------------------------	--------------------------------	-------------------------------

Master Drawing No: 1208338_COP020_12086_CA0190_M002 Issue: B


100mm
50mm
10mm

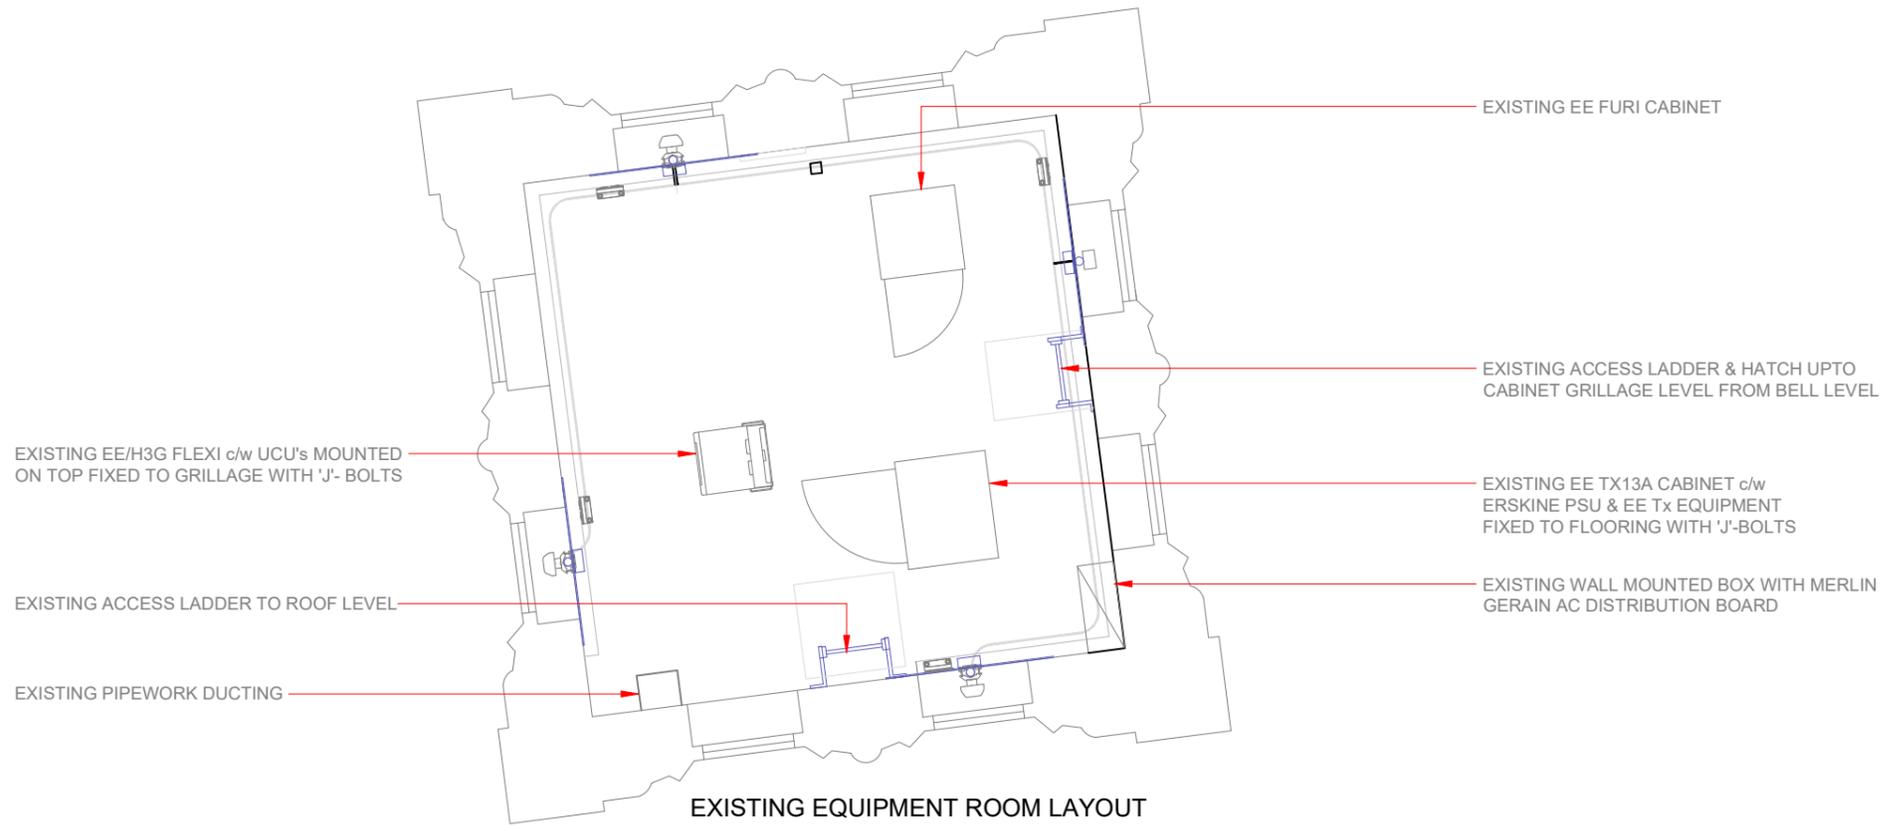

EXISTING EQUIPMENT ROOM LAYOUT

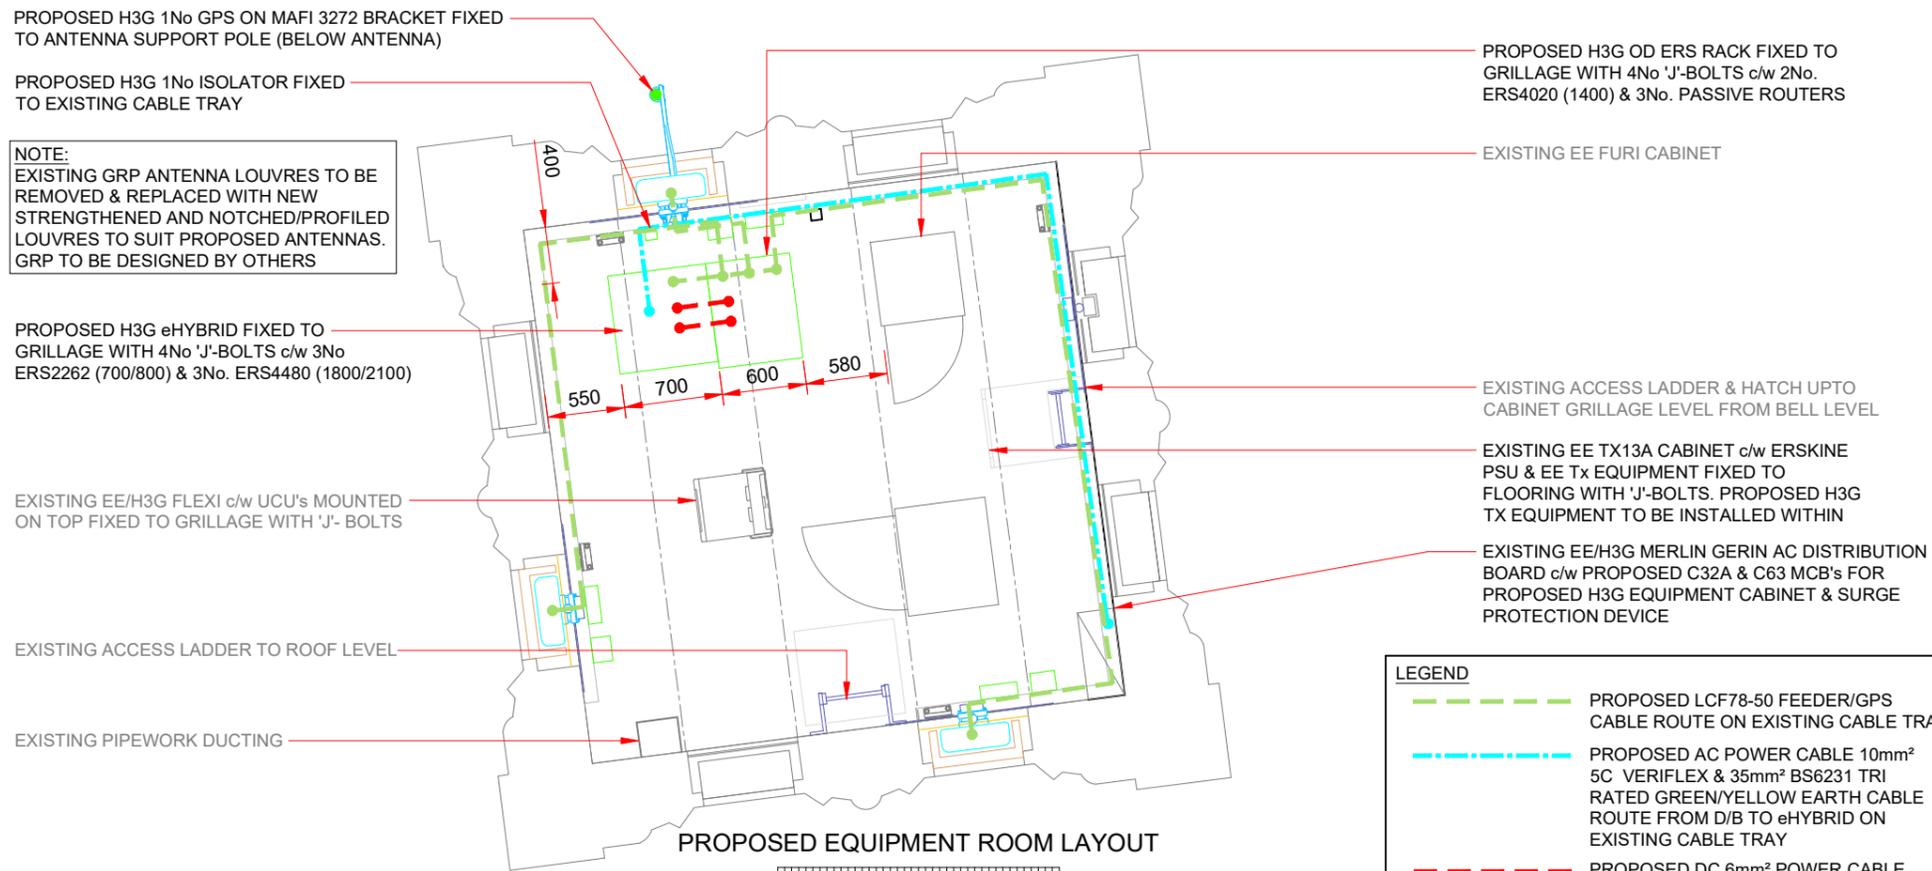 

PROPOSED EQUIPMENT ROOM LAYOUT

 

LEGEND

- PROPOSED LCF78-50 FEEDER/GPS CABLE ROUTE ON EXISTING CABLE TRAY
- PROPOSED AC POWER CABLE 10mm² 5C VERIFLEX & 35mm² BS6231 TRI RATED GREEN/YELLOW EARTH CABLE ROUTE FROM D/B TO eHYBRID ON EXISTING CABLE TRAY
- PROPOSED DC 6mm² POWER CABLE 'ROSENBERGER SL2C6MM2FRNC-S-BK' ROUTE FROM eHYBRID TO ERS RACK ON PROPOSED CABLE TRAY

NOTES:
1. ALL DIMENSIONS IN MM UNLESS OTHERWISE NOTED.

Master: M002	MBNL / EE / H3G: MBNL	Project: MBNL - 3UK BUY-IN	Purpose of Issue: Detailed Design	Issue: B
Date: 24/03/2023	Drawn: S.Bevan	Revision / Upgrade Description: Major Rev - Power Notes Revised, Cabinet Details Added, NGR Corrected, GPS Mounting Position Changed, Schedules Updated & Antenna Mounting Scheme Revised as Per Site Revisit/Notes		
Checked: A.Dobson	Approved: A.Dobson			
Master: M001	MBNL / EE / H3G: MBNL	Project: MBNL - 3UK BUY-IN	Purpose of Issue: Detailed Design	Issue: A
Date: 29/11/2022	Drawn: R.Sweeney	Revision / Upgrade Description: First Issue - Detailed Design		
Checked: A.Dobson	Approved: A.Dobson			

Hutchison 3G UK Limited
Green Park, 450 Longwater Avenue
Reading, RG20 3UR
Tel: 01628 765 900
Fax: 01628 765 901

H3G Base Station Information line:
0845 6043000
Available 8am-8pm Monday to Friday

Hatfield Business Park
Hatfield
Hertfordshire
AL10 9BW
Tel: 01707 315000
Fax: 01707 319001

MBNL Mobile Broadband Network Limited
Sixth Floor, Thames Tower, Station Road, Reading, RG1 1LX

Design Consultant & Principal Contractor:

Unit E, Madison Place, Northampton Road,
Manchester, M40 5AG
Tel: 0161 785 4500 Fax: 0161 785 4501
Web: www.clarke-telecom.com

Site Name: **PARISH CHURCH EGREMONT**

Site ID: **1208338**

Address: **PARISH CHURCH EGREMONT
ST MARY AND ST MICHAEL
SOUTH STREET
EGREMONT, CUMBRIA
CA22 2AW**

Title: **330 EQUIPMENT ROOM LAYOUT**


Project: **MBNL - 3UK BUY-IN**

Purpose of Issue: **DETAILED DESIGN**


EE Cell ID: 12086	MBNL Cell ID: COP020	3UK Cell ID: CA0190
-----------------------------	--------------------------------	-------------------------------

Master Drawing No: **1208338_COP020_12086_CA0190_M002** Issue: **B**

100mm
50mm
10mm

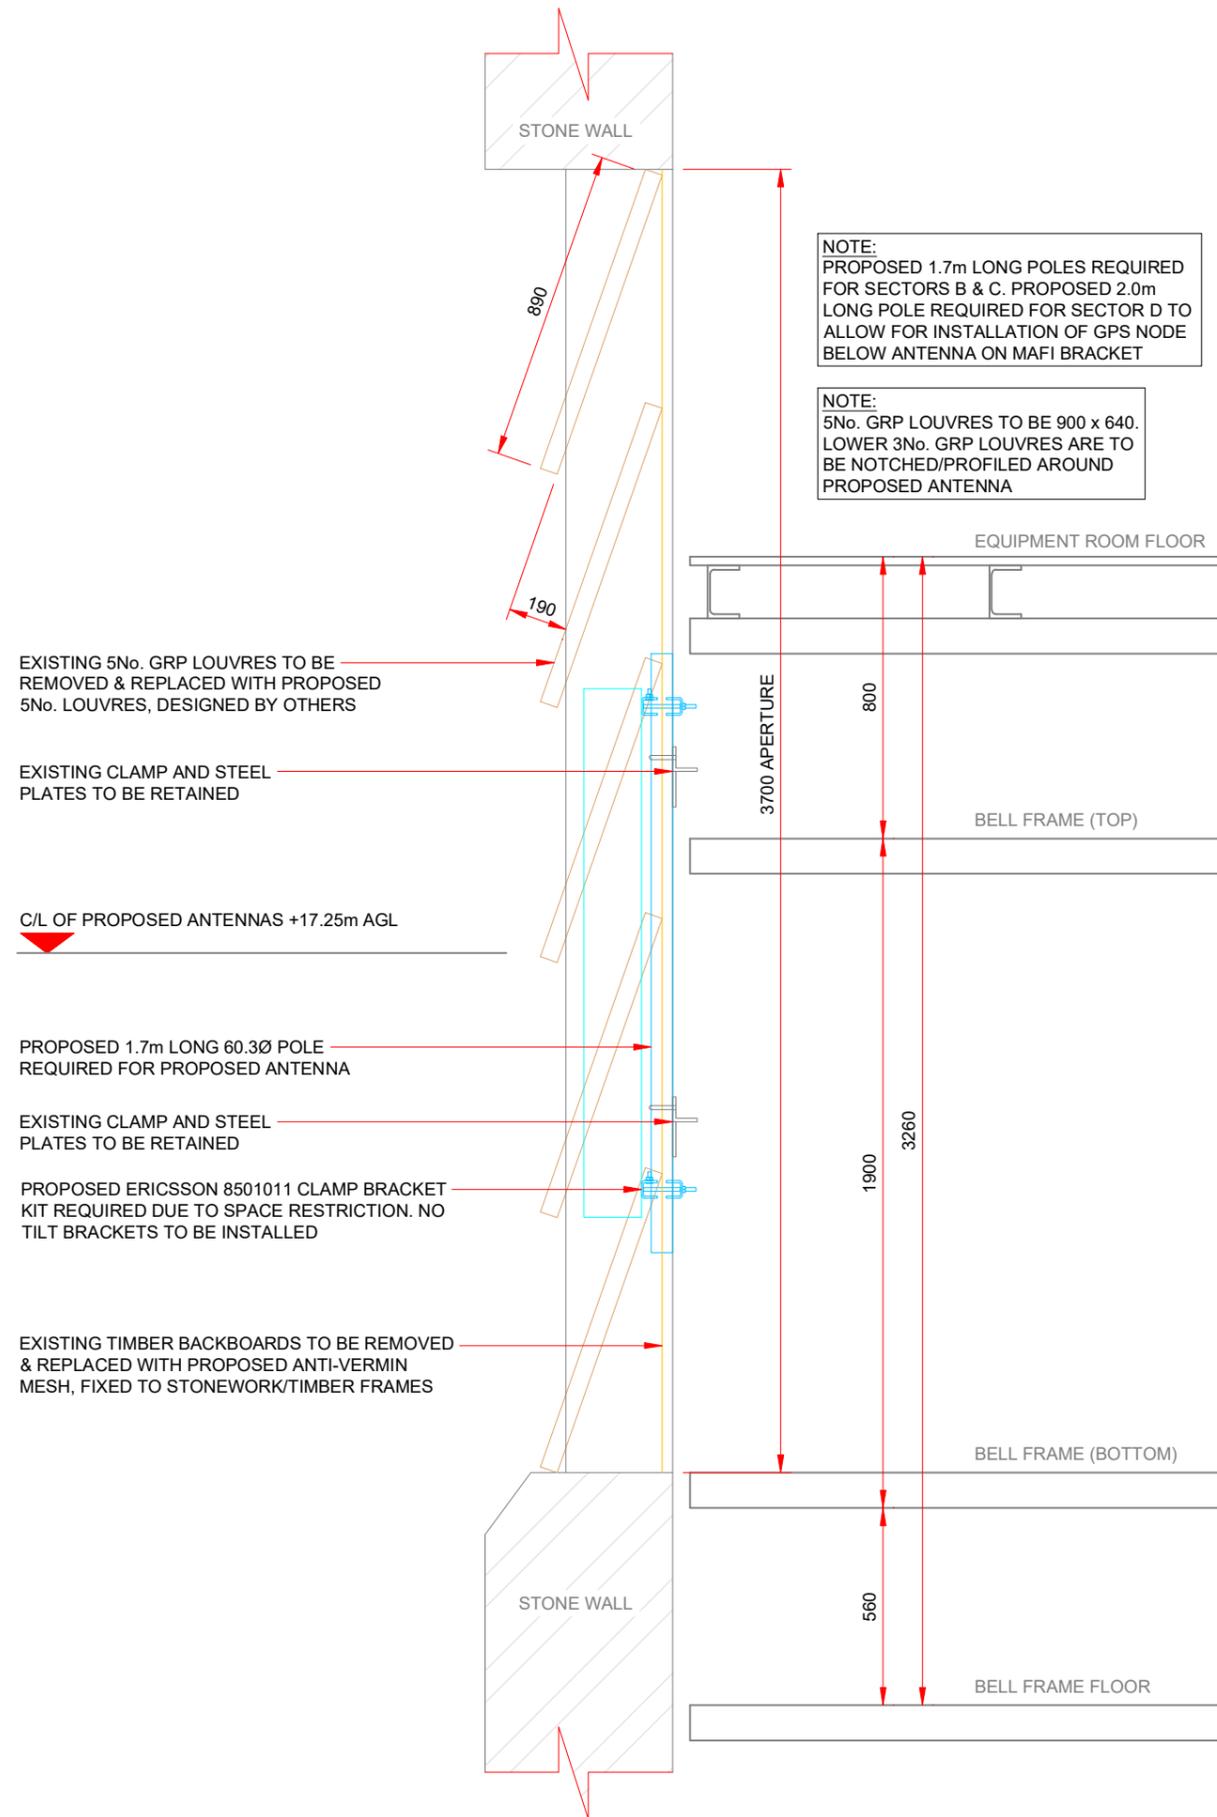

 TYP. SECTION ON ANTENNA FIXING DETAILS WITHIN APERTURES



NOTES:
1. ALL DIMENSIONS IN MM UNLESS OTHERWISE NOTED.

Master	MBNL / EE / H3G	Project	Purpose of Issue	Issue
M002	MBNL	MBNL - 3UK BUY-IN	Detailed Design	B
Date:	24/03/2023	Revision / Upgrade Description:		
Drawn:	S.Bevan	Major Rev - Power Notes Revised, Cabinet Details Added, NGR Corrected, GPS Mounting Position Changed, Schedules Updated & Antenna Mounting Scheme Revised as Per Site Revisit/Notes		
Checked:	A.Dobson			
Approved:	A.Dobson			
Master	MBNL / EE / H3G	Project	Purpose of Issue	Issue
M001	MBNL	MBNL - 3UK BUY-IN	Detailed Design	A
Date:	29/11/2022	Revision / Upgrade Description:		
Drawn:	R.Sweeney	First Issue - Detailed Design		
Checked:	A.Dobson			
Approved:	A.Dobson			

 Hutchison 3G UK Limited Green Park, 450 Longwater Avenue Reading, RG20 3UR Tel: 01628 765 900 Fax: 01628 765 901	 Hatfield Business Park Hatfield Hertfordshire AL10 9BW Tel: 01707 315000 Fax: 01707 319001
--	---

MBNL Mobile Broadband Network Limited
Sixth Floor, Thames Tower, Station Road, Reading, RG1 1LX

Design Consultant & Principal Contractor:

CLARKE
 telecom
 Unit E, Madison Place, Northampton Road,
 Manchester, M40 5AG
 Tel: 0161 785 4500 Fax: 0161 785 4501
 Web: www.clarke-telecom.com

Site Name: **PARISH CHURCH EGREMONT**

Site ID: **1208338**

Address:
**PARISH CHURCH EGREMONT
ST MARY AND ST MICHAEL
SOUTH STREET
EGREMONT, CUMBRIA
CA22 2AW**

Title: **500 ANTENNA MOUNTING DETAILS 1 of 2**

Project: **MBNL - 3UK BUY-IN**

Purpose of Issue: **DETAILED DESIGN**

EE Cell ID: 12086	MBNL Cell ID: COP020	3UK Cell ID: CA0190
-----------------------------	--------------------------------	-------------------------------

Master Drawing No: **1208338_COP020_12086_CA0190_M002** Issue: **B**

100mm
50mm
10mm